



REVISION

PROJECT

INTERIOR DESIGN FOR
13TH STREET APARTMENT

(FOURTH FLOOR)

OWNER / APPLICANT

SUBJECT

WALLING PLAN

SCALE

1:100

DATE


L.S

SHEET NO.

4F-I-1.01


- EXISTING BRICK WALL
- NEW BRICK WALL
- NEW DRY WALL
(8MM TK CEMENT BOARD)

TEMPERED GLASS

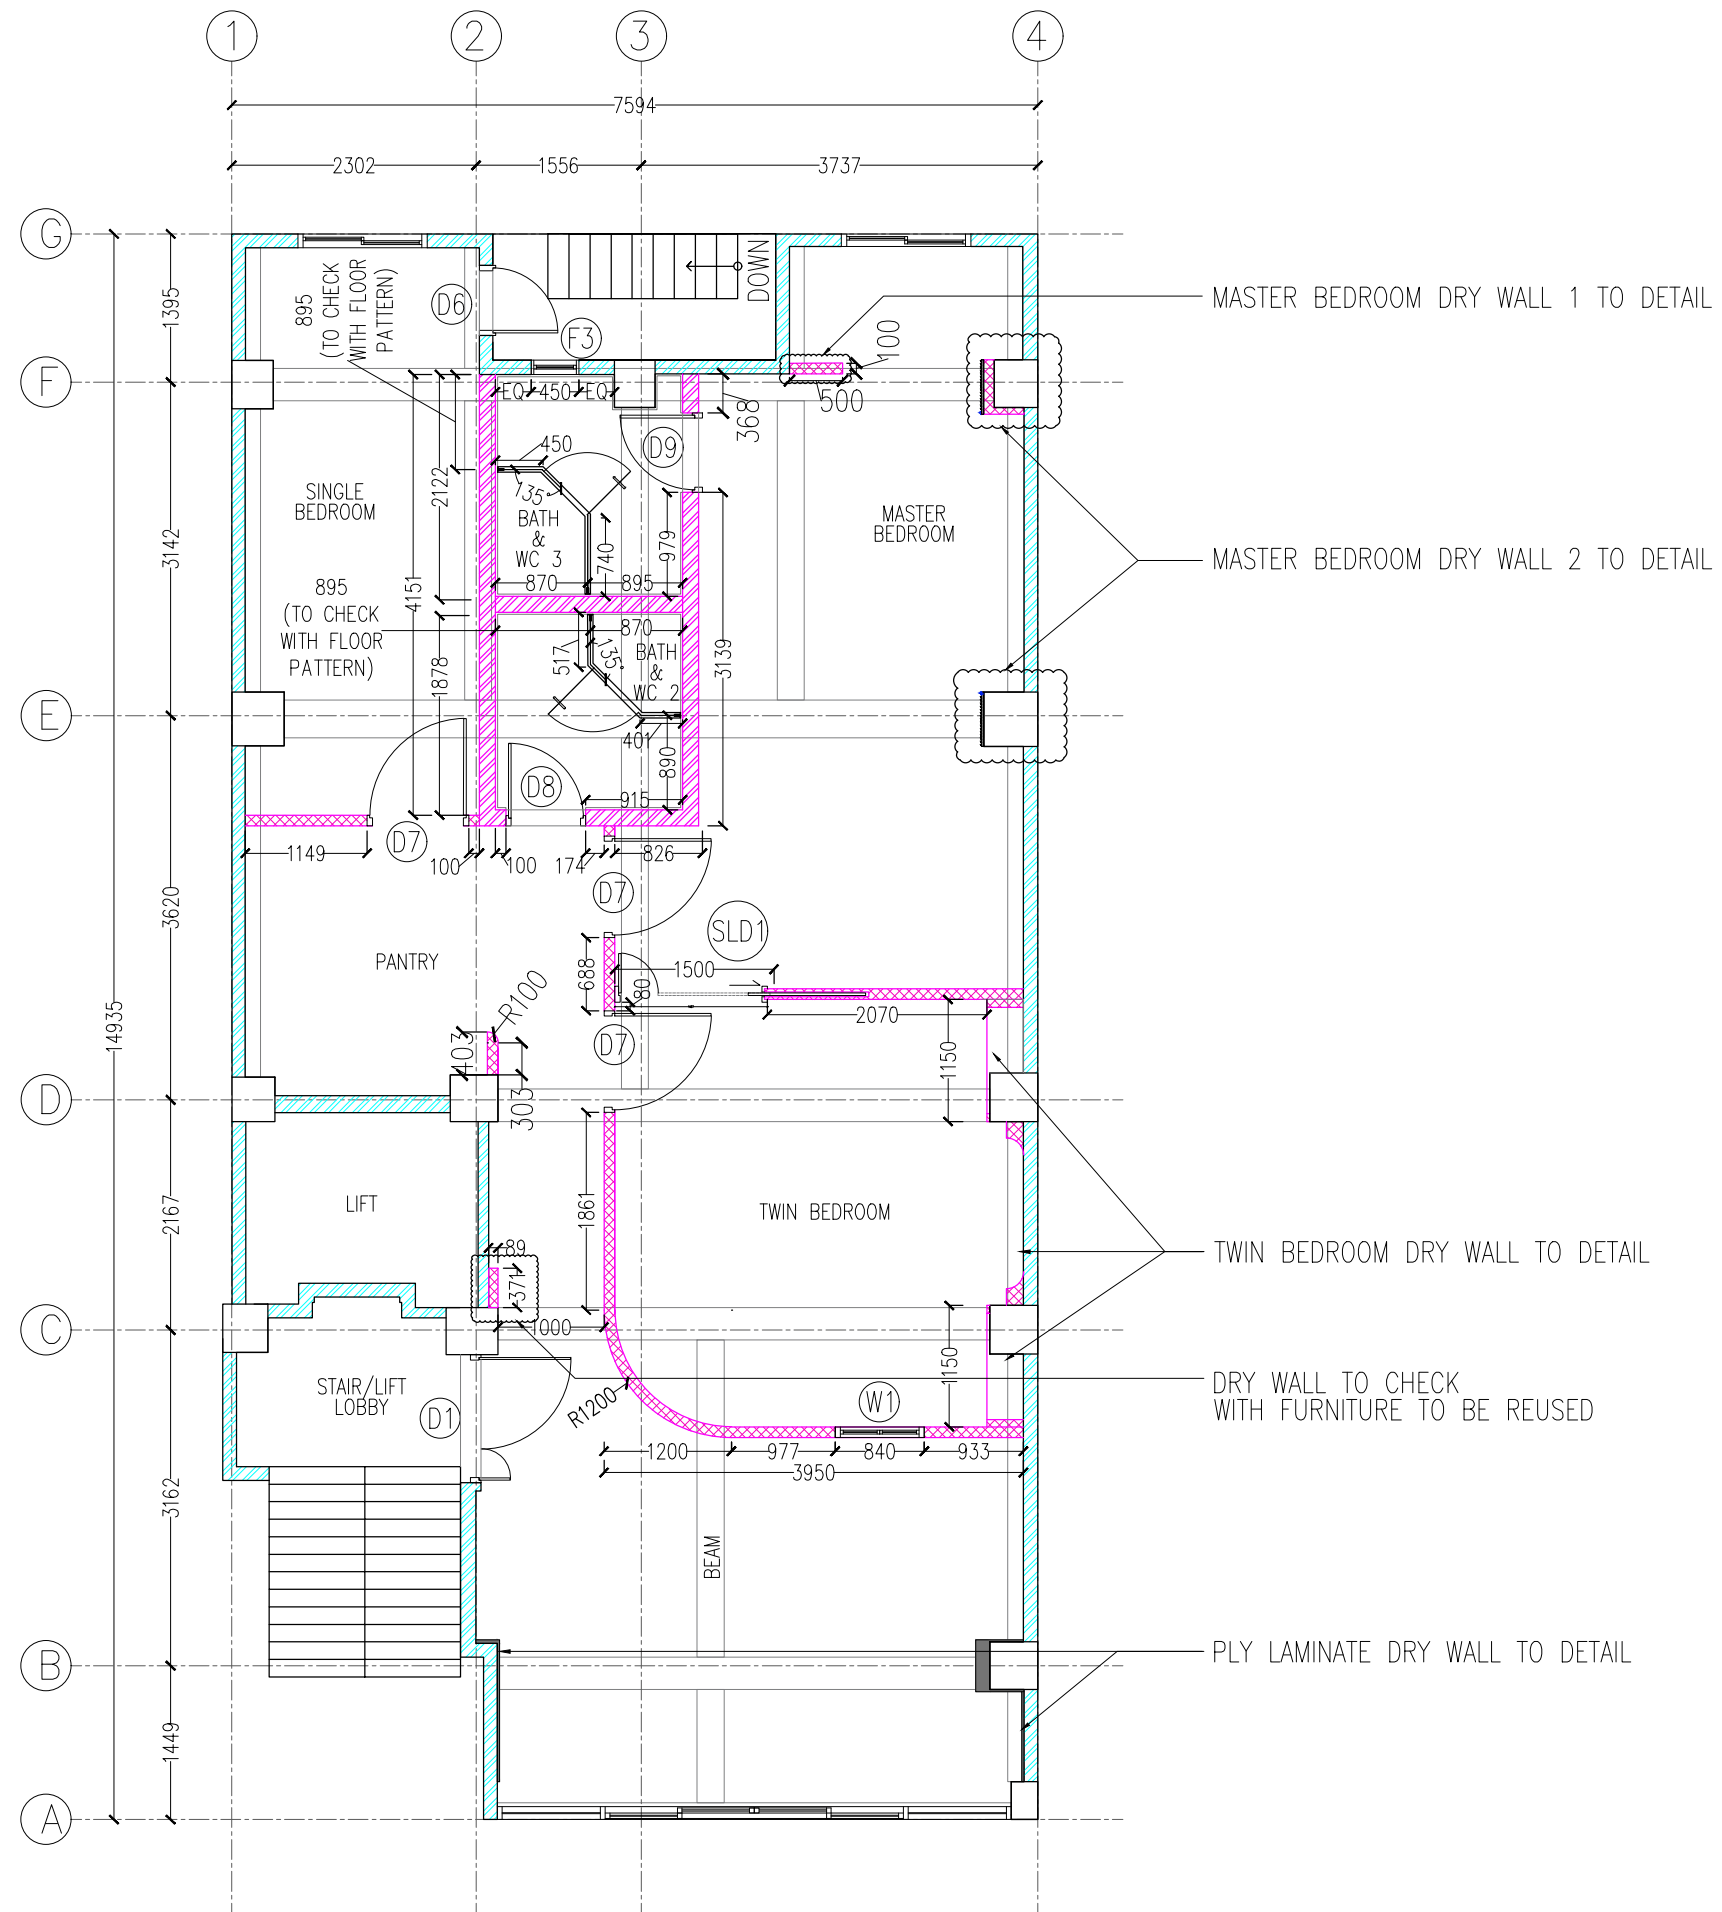


(FOURTH FLOOR)

- EXISTING BRICK WALL
- NEW BRICK WALL
- NEW DRY WALL
(8MM TK CEMENT BOARD)
- SKIRTING
- VINYL FLOORING
- GRANITE
- SKIRTING LINE

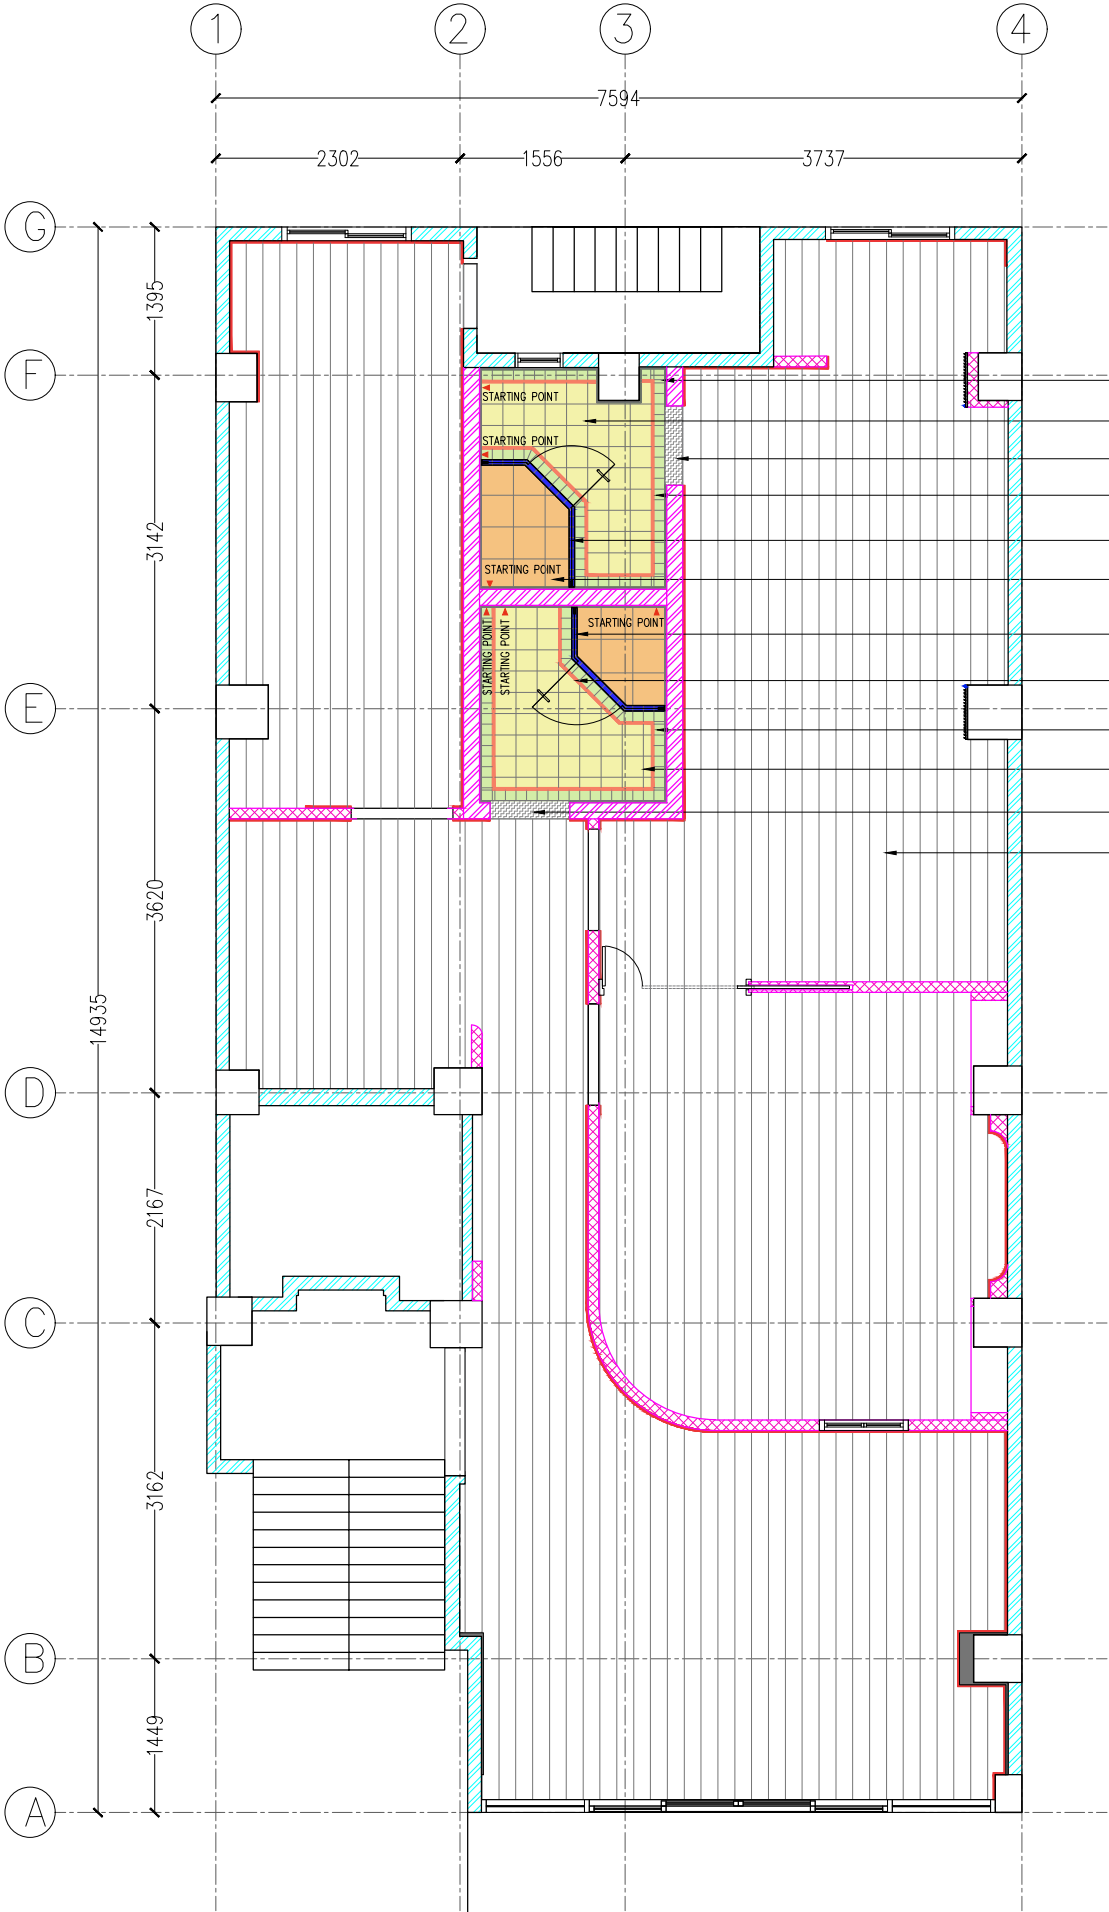

- FLOOR TILE 3
- FLOOR TILE 2
- GRANITE
- MOSAIC FLOOR TILE
- KERB WITH FLOOR TILE 3
- FLOOR TILE 1
- KERB WITH FLOOR TILE 3
- MOSAIC FLOOR TILE
- FLOOR TILE 3
- FLOOR TILE 2
- GRANITE
- VINYL FLOORING

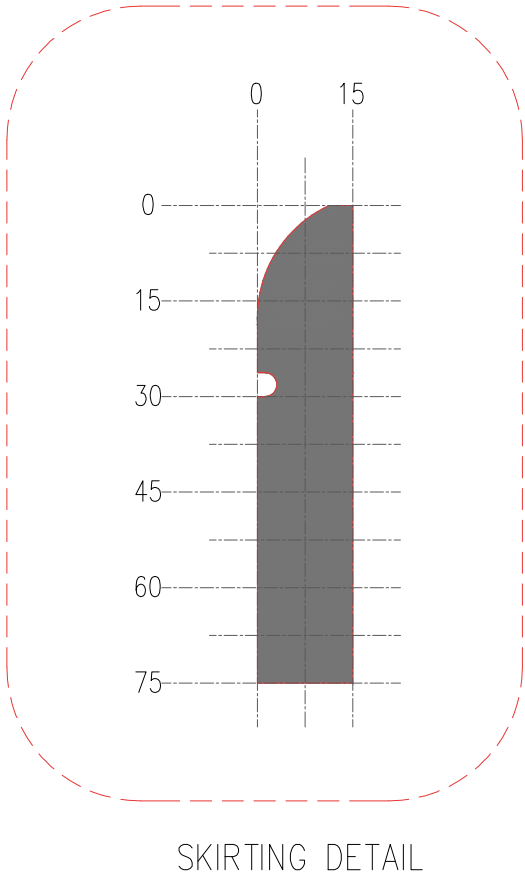

- FLOOR TILE 1
(300MM X 300MM NON-SLIP
HOMOGENEOUS FLOOR TILE) TO SELECTION
- FLOOR TILE 2
(200MM X 200MM NON-SLIP
HOMOGENEOUS FLOOR TILE) TO SELECTION
- FLOOR TILE 3
(100MM X 100MM NON-SLIP
HOMOGENEOUS FLOOR TILE) TO SELECTION
- KERB WITH FLOOR TILE 3
(100MM X 100MM NON-SLIP
HOMOGENEOUS FLOOR TILE) TO SELECTION
- MOSAIC FLOOR TILE
(25MM X 25MM NON-SLIP
HOMOGENEOUS FLOOR TILE) TO SELECTION



REVISION

PROJECT

INTERIOR DESIGN FOR
13TH STREET APARTMENT

(FOURTH FLOOR)

OWNER / APPLICANT

SUBJECT

FLOOR FINISHED PLAN

SCALE

1:100

DATE

L.S

SHEET NO.


4F-I-1.02

(FOURTH FLOOR)

- SINGLE BEDROOM SHELF 1 TO DETAIL
- CABINET AND SHELF TO DETAIL
- STORAGE CABINET TO DETAIL
- SINGLE BEDROOM SHELF 2 TO DETAIL
- BATH & WC 2 SHELF 1 TO DETAIL
- BATH & WC 2 SHELF 2 TO DETAIL
- SINGLE BED 1 TO DETAIL
- CORNER SHELF TO SELECTION
- SINGLE BEDROOM CARPET TO SELECTION
- BATH & WC 3 SHELF TO DETAIL
- CORNER SHELF TO SELECTION
- SINGLE BEDROOM WARDROBE TO DETAIL

- DRESSING TABLE TO DETAIL
- DRESSING CHAIR TO SELECTION
- MASTER BEDROOM WARDROBE 1 TO DETAIL
- BEDSIDE TABLE TO DETAIL
- BATH & WC 1 VANITY COUNTER TO DETAIL
- MASTER BEDROOM CARPET TO SELECTION
- BEDSIDE TABLE TO DETAIL
- BATH & WC 2 VANITY COUNTER TO DETAIL
- MASTER BEDROOM WARDROBE 2 TO DETAIL
- MIRROR TO DETAIL
- REFRIGERATOR TO SELECTION
- BASIN COUNTER TO DETAIL
- TALL UNIT TO DETAIL
- SINGLE BED 2 TO DETAIL
- STUDY TABLE TO DETAIL
- TWIN BEDROOM SHELF TO DETAIL
- TWIN BEDROOM CHAIR TO SELECTION
- TWIN BEDROOM WARDROBE TO DETAIL
- SINGLE BED 3 TO DETAIL
- FAMILY ROOM SHELF 1 TO DETAIL
- BEAN BAGS TO SELECTION
- FAMILY ROOM SHELF 2 TO DETAIL
- PILLOWS TO SELECTION

- EXISTING BRICK WALL
- NEW BRICK WALL
- NEW DRY WALL
(8MM TK CEMENT BOARD)
- SKIRTING LINE

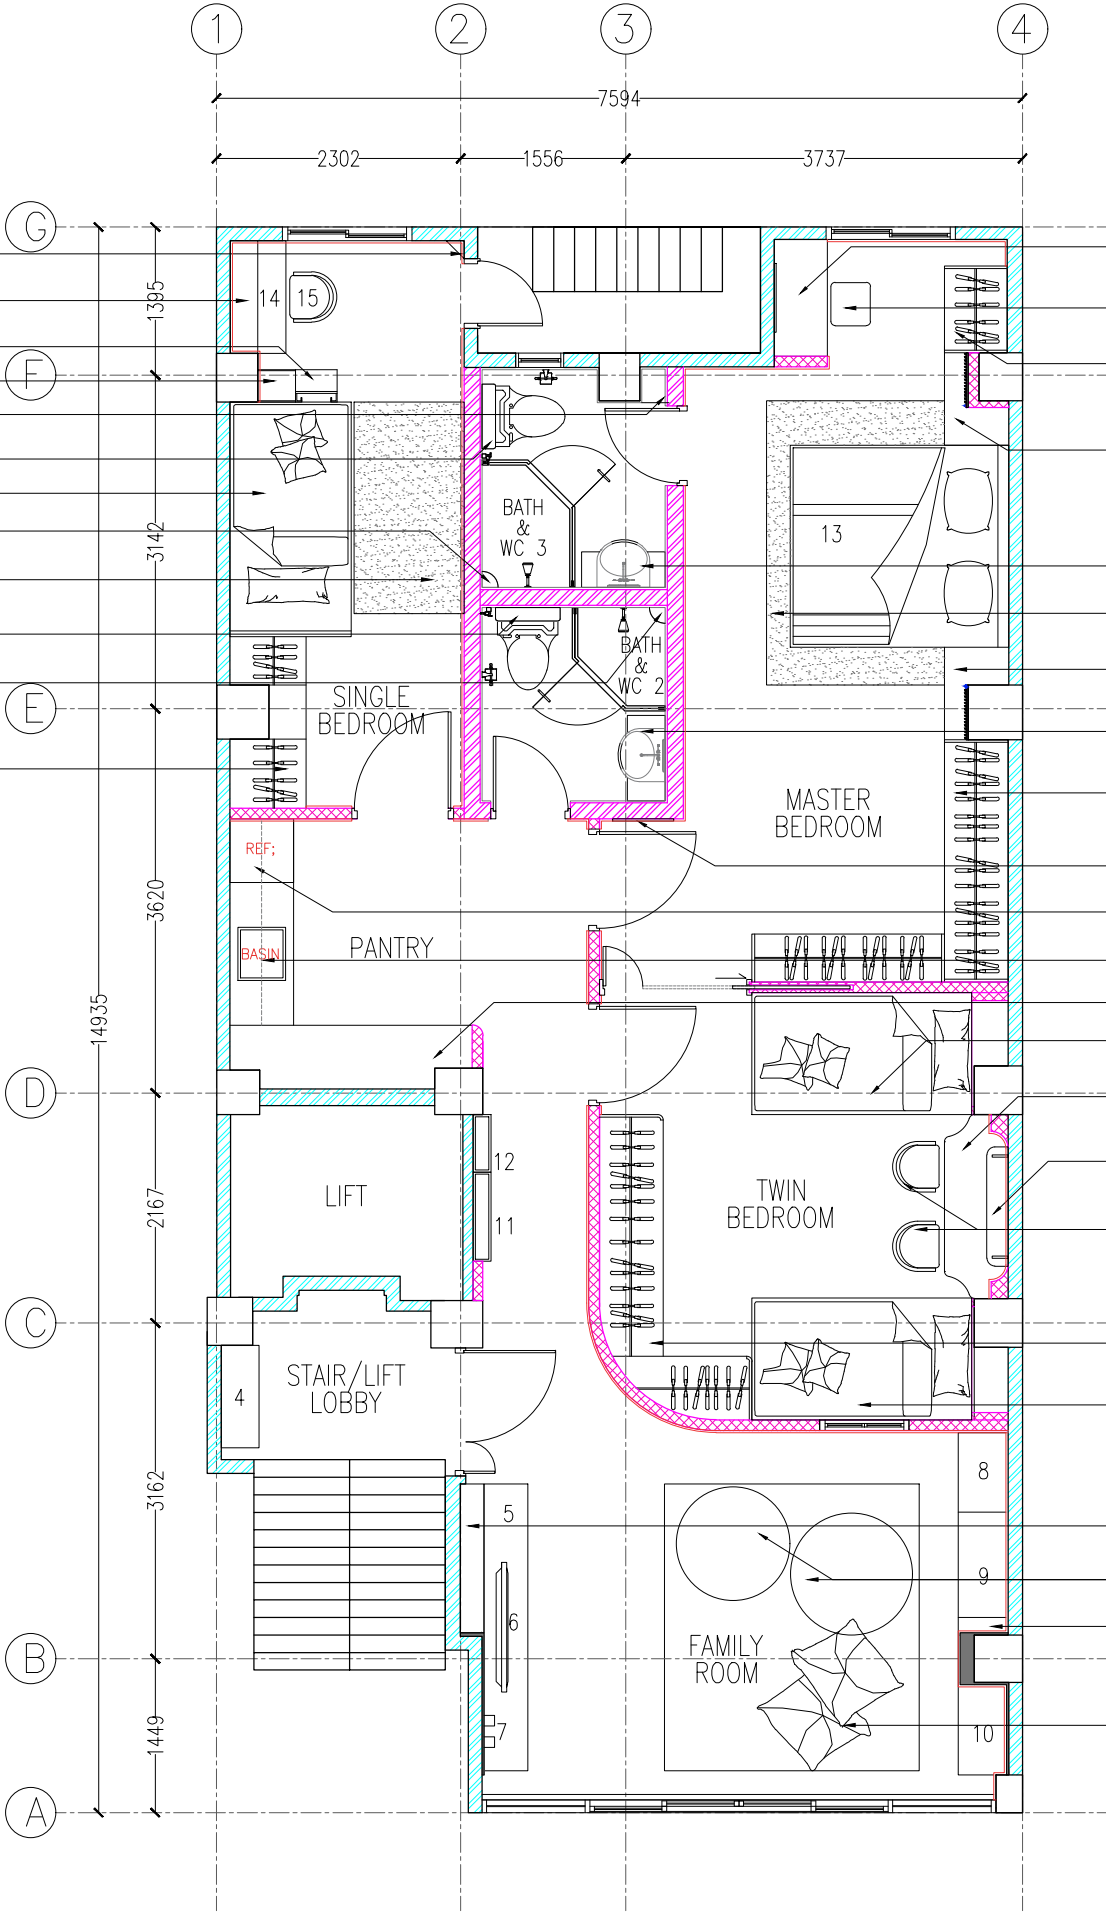

REVISION

PROJECT

INTERIOR DESIGN FOR
13TH STREET APARTMENT
(FOURTH FLOOR)

OWNER / APPLICANT

SUBJECT

FURNITURE LAYOUT PLAN

SCALE

1:100

DATE

L.S



SHEET NO.

4F-I-1.03


(FOURTH FLOOR)

- CEILING LINE
- CL +2146MM
 - CL +2133MM
 - CL +2200MM
 - CL +2250MM
 - CL +2283MM
 - CL +2330MM
 - CL +2467MM
 - CL +2478MM
 - CL +2553MM
 - CL +2554MM

NOTE: CEILING LEVELS ARE MEASURED FROM F.F.L.

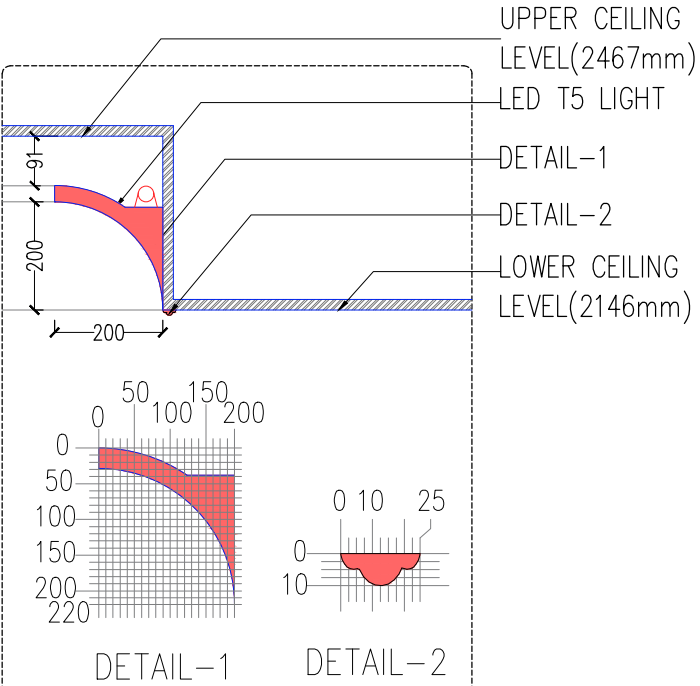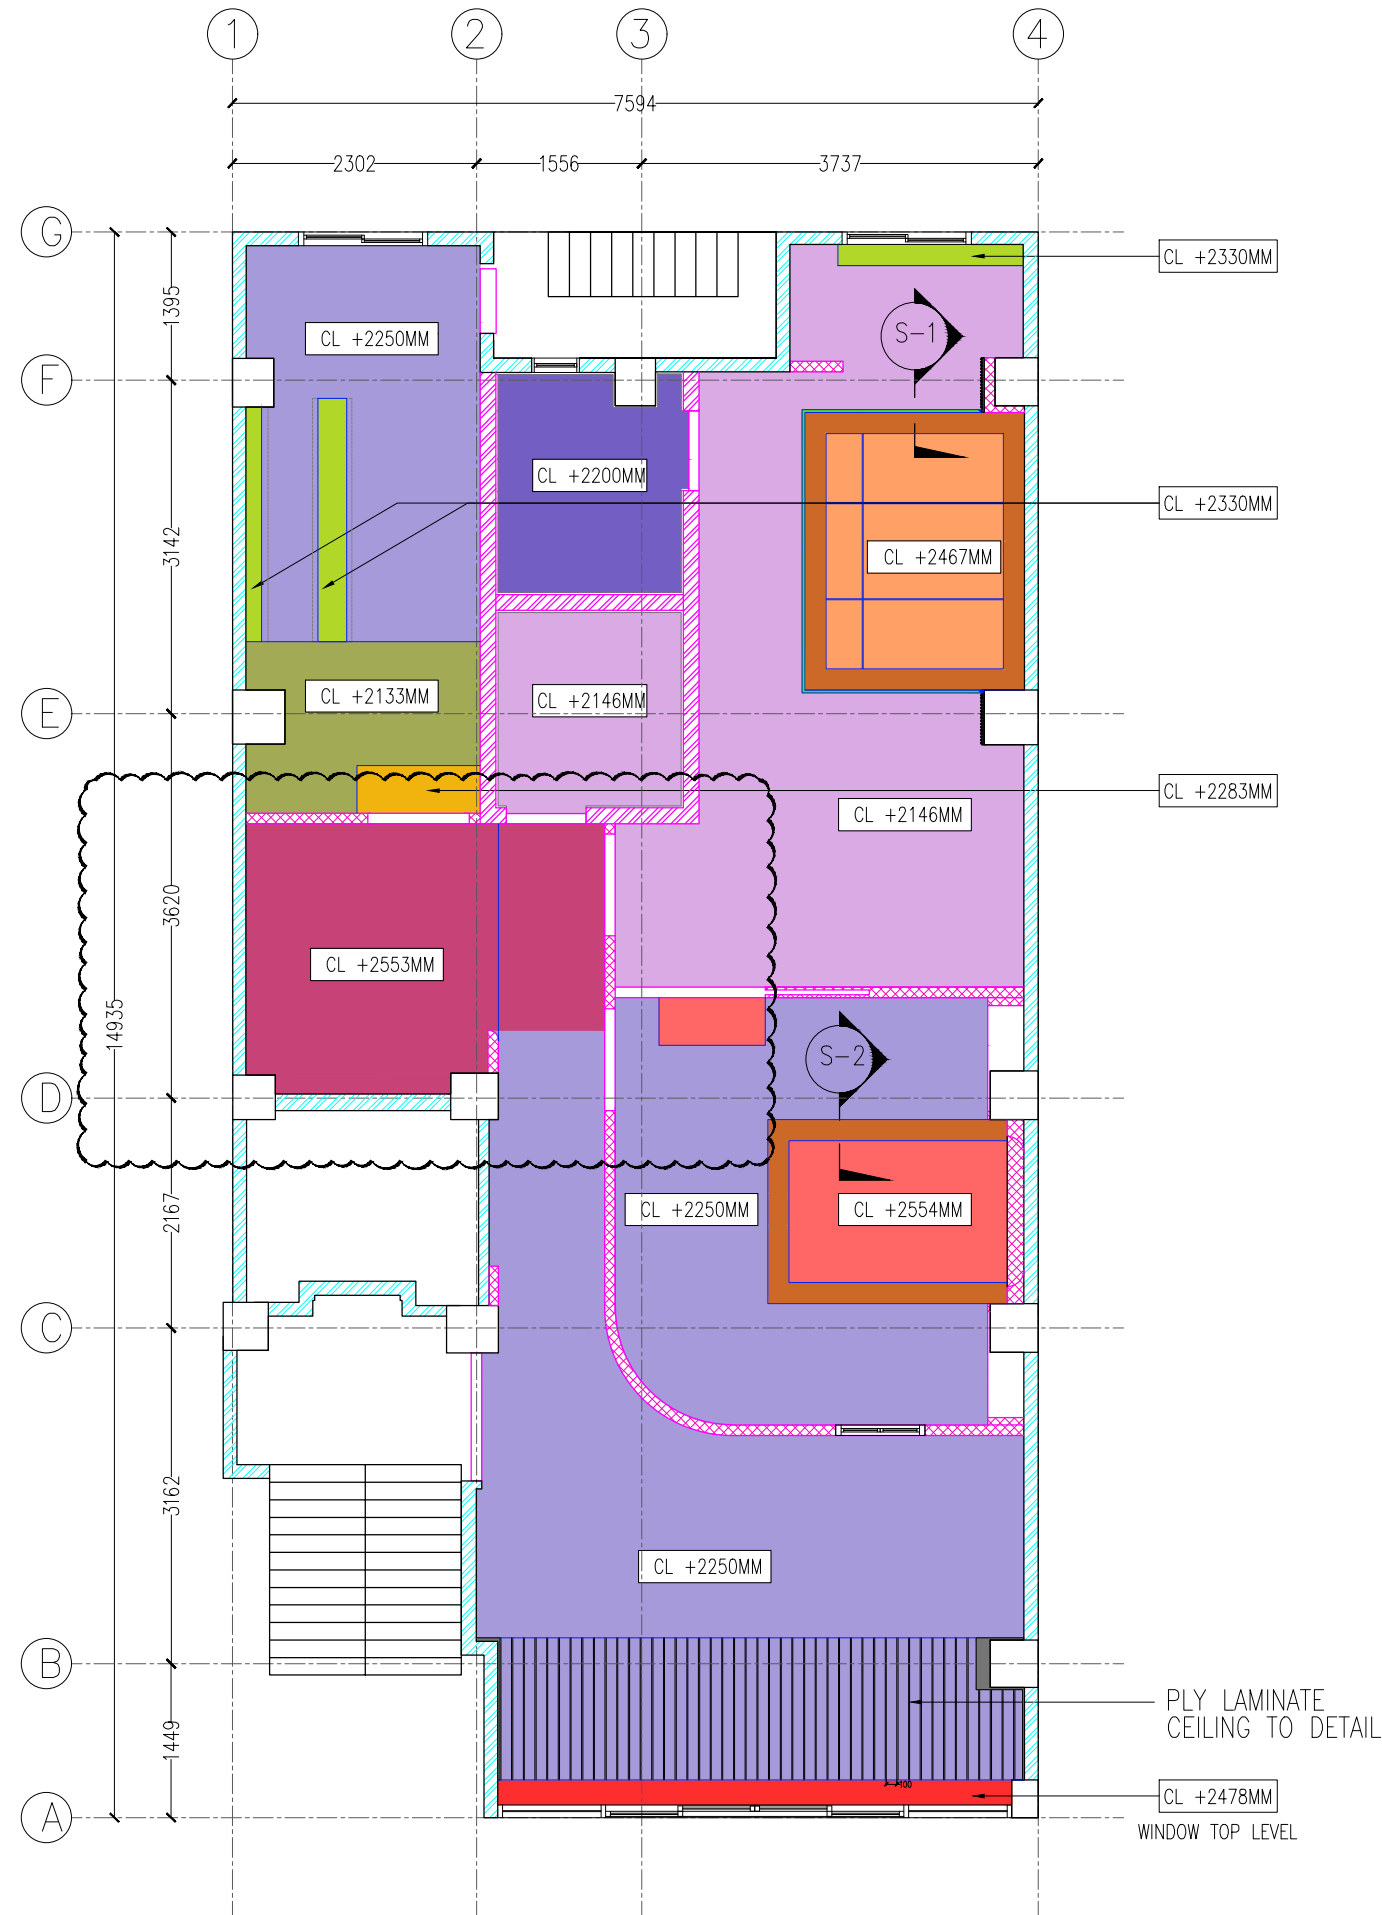

SECTION-1

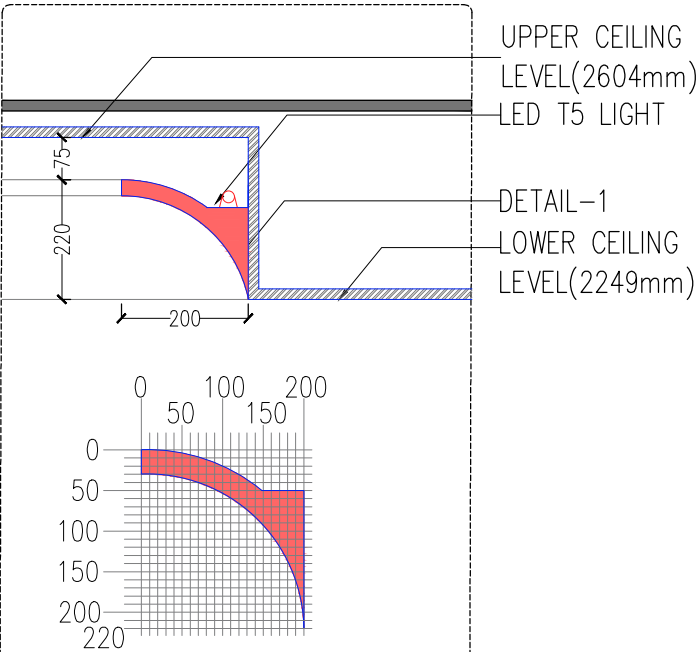

SECTION-2

- EXISTING BRICK WALL
- NEW BRICK WALL
- NEW DRY WALL (8MM TK CEMENT BOARD)



REVISION

PROJECT

INTERIOR DESIGN FOR
13TH STREET APARTMENT
(FOURTH FLOOR)

OWNER / APPLICANT

SUBJECT

CEILING PLAN
(SHOWING CEILING LEVEL)

SCALE

1:100

DATE

L.S

SHEET NO.


4F-I-1.04

(FOURTH FLOOR)

DESIGNED WALLPAPER ON CEILING

- CEILING LINE
- EXISTING BRICK WALL
- NEW BRICK WALL
- NEW DRY WALL
(8MM TK CEMENT BOARD)
- PLASTERBOARD CEILING (9MM)

NOTE: CEILING LEVELS ARE MEASURED FROM F.F.L.

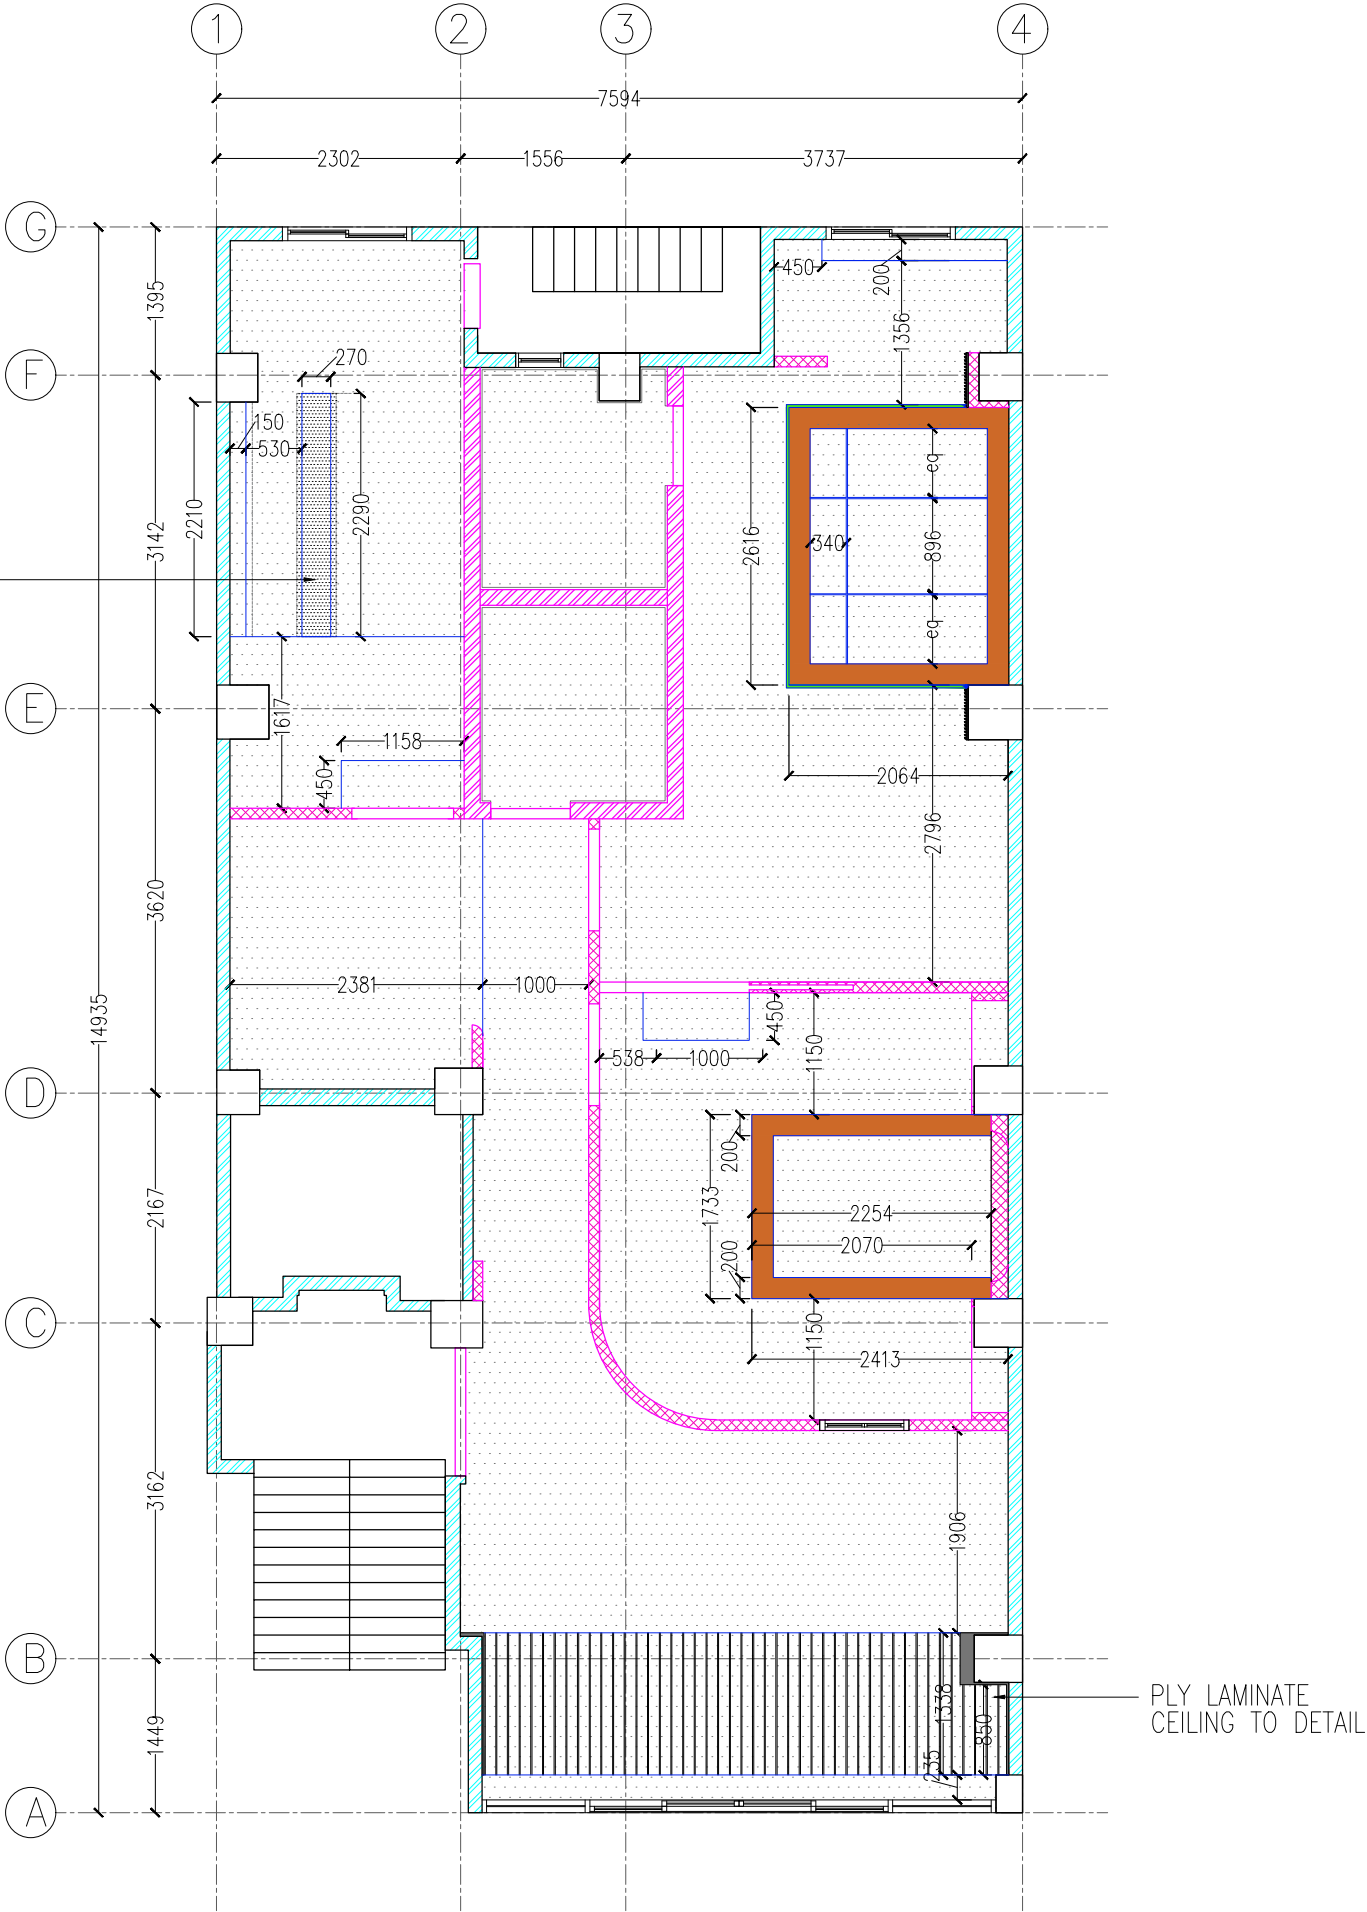

REVISION

PROJECT

INTERIOR DESIGN FOR
13TH STREET APARTMENT

(FOURTH FLOOR)

OWNER / APPLICANT

SUBJECT

CEILING PLAN
(SHOWING DIMENSIONS)

SCALE

1:100


DATE

L.S

SHEET NO.

4F-I-1.05

(FOURTH FLOOR)

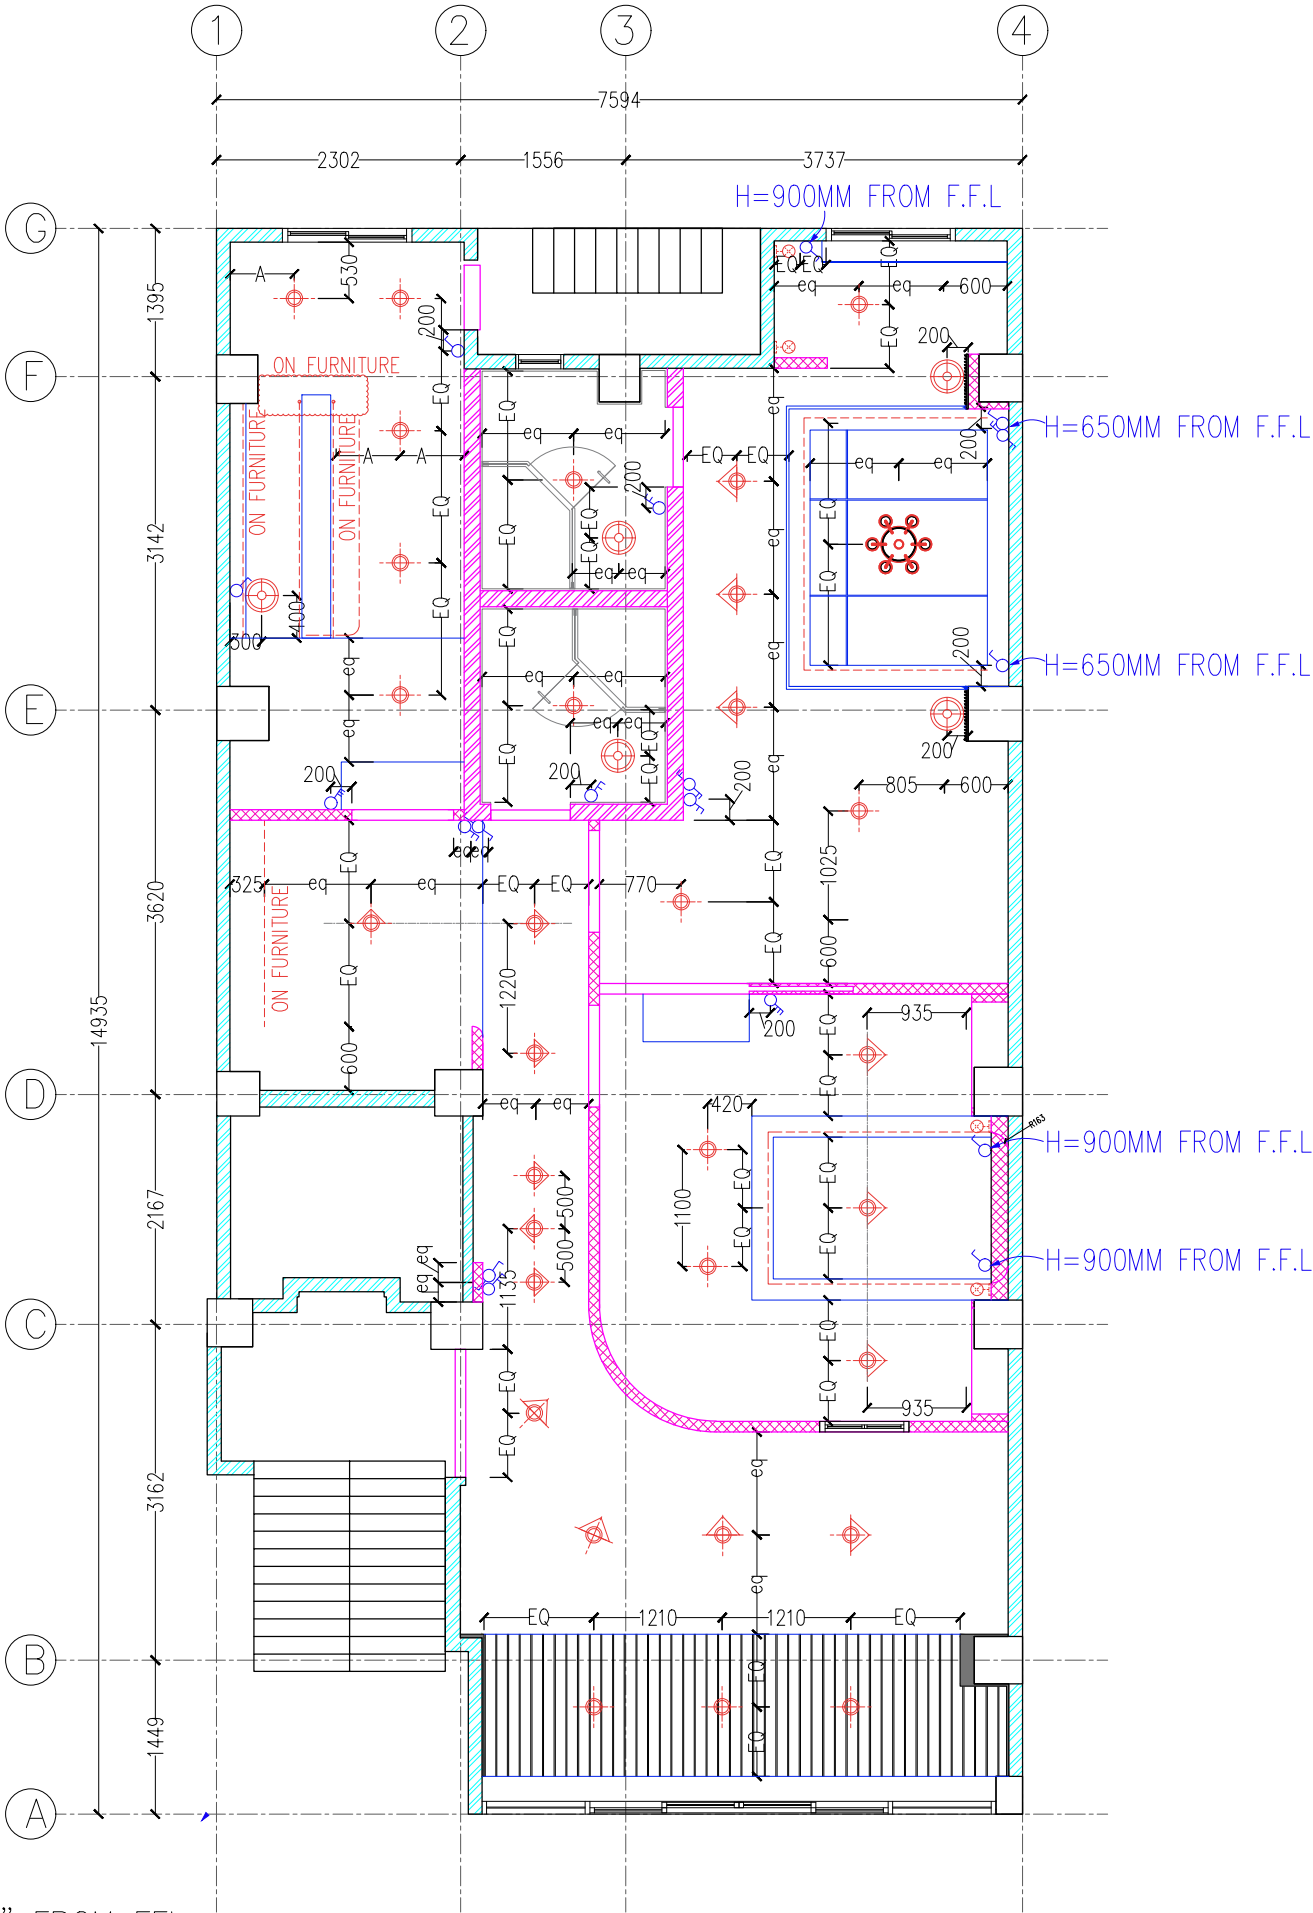

- EXISTING BRICK WALL
- NEW BRICK WALL
- NEW DRY WALL (8MM TK CEMENT BOARD)

Note: HEIGHT OF SWITCH CENTER = 4'-0" FROM FFL.
HEIGHT OF PANDENT LIGHTS (H) ARE MEASURED BETWEEN THE FIXTURE BOTTOM AND FLOOR FINISH LEVEL
THIS DRAWING IS NOT A M&E DRAWING. CHECKING AND NEGOTIATION WILL BE DONE BY M&E CONSULTANT.

- CEILING LINES
- LED LIGHT STRIP
- 1 GANG SWITCH
- 2 GANG SWITCH
- 3 GANG SWITCH
- 1 GANG 2 WAY SWITCH
- 2 GANG 2 WAY SWITCH
- DATA ROUTER
- WALL MOUNTED LAMP
- LED DOWN LIGHT
- LED SPOT LIGHT
- PENDENT LIGHT
- CHANDELIER



REVISION

PROJECT

INTERIOR DESIGN FOR
13TH STREET APARTMENT
(FOURTH FLOOR)

OWNER / APPLICANT

SUBJECT

LIGHTING PLAN
(SHOWING FIXTURE AND
SWITCH LOCATION)

SCALE

1:100


DATE

L.S

SHEET NO.

4F-I-1.06

(FOURTH FLOOR)

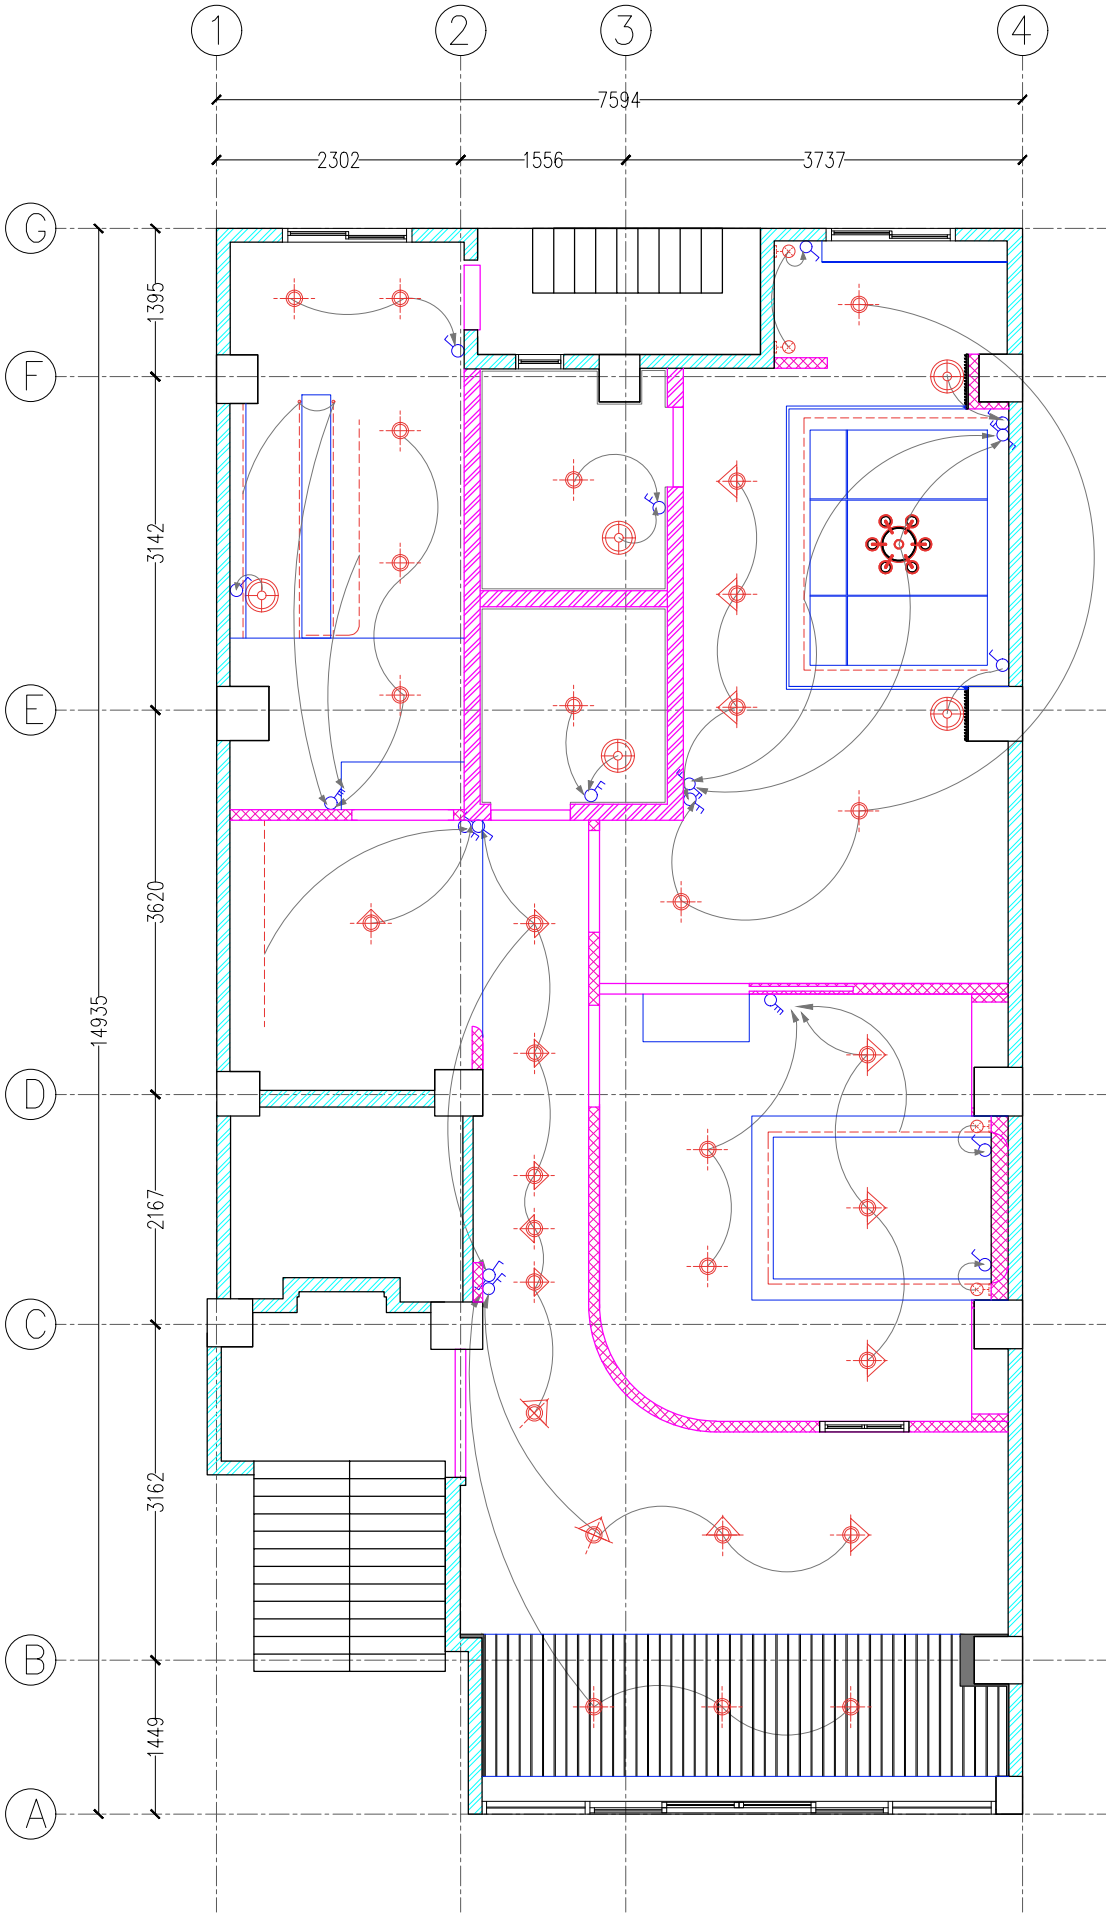

- EXISTING BRICK WALL
- NEW BRICK WALL
- NEW DRY WALL
(8MM TK CEMENT BOARD)

- LED LIGHT STRIP
- CEILING LINES
- 1 GANG SWITCH
- 2 GANG SWITCH
- 3 GANG SWITCH
- 1 GANG 2 WAY SWITCH
- 2 GANG 2 WAY SWITCH
- WALL MOUNTED LAMP
- LED DOWN LIGHT
- LED SPOT LIGHT
- PENDENT LIGHT
- CHANDELIER

NOTE: THIS DRAWING IS NOT A M&E DRAWING. CHECKING AND NEGOTIATION WILL BE DONE BY M&E CONSULTANT.



REVISION

PROJECT

INTERIOR DESIGN FOR
13TH STREET APARTMENT

(FOURTH FLOOR)

OWNER / APPLICANT

SUBJECT

LIGHTING PLAN
(SHOWING CONNECTION
WITH LIGHT SWITCHES)

SCALE

1:100


DATE

L.S

SHEET NO.

4F-I-1.07

(FOURTH FLOOR)

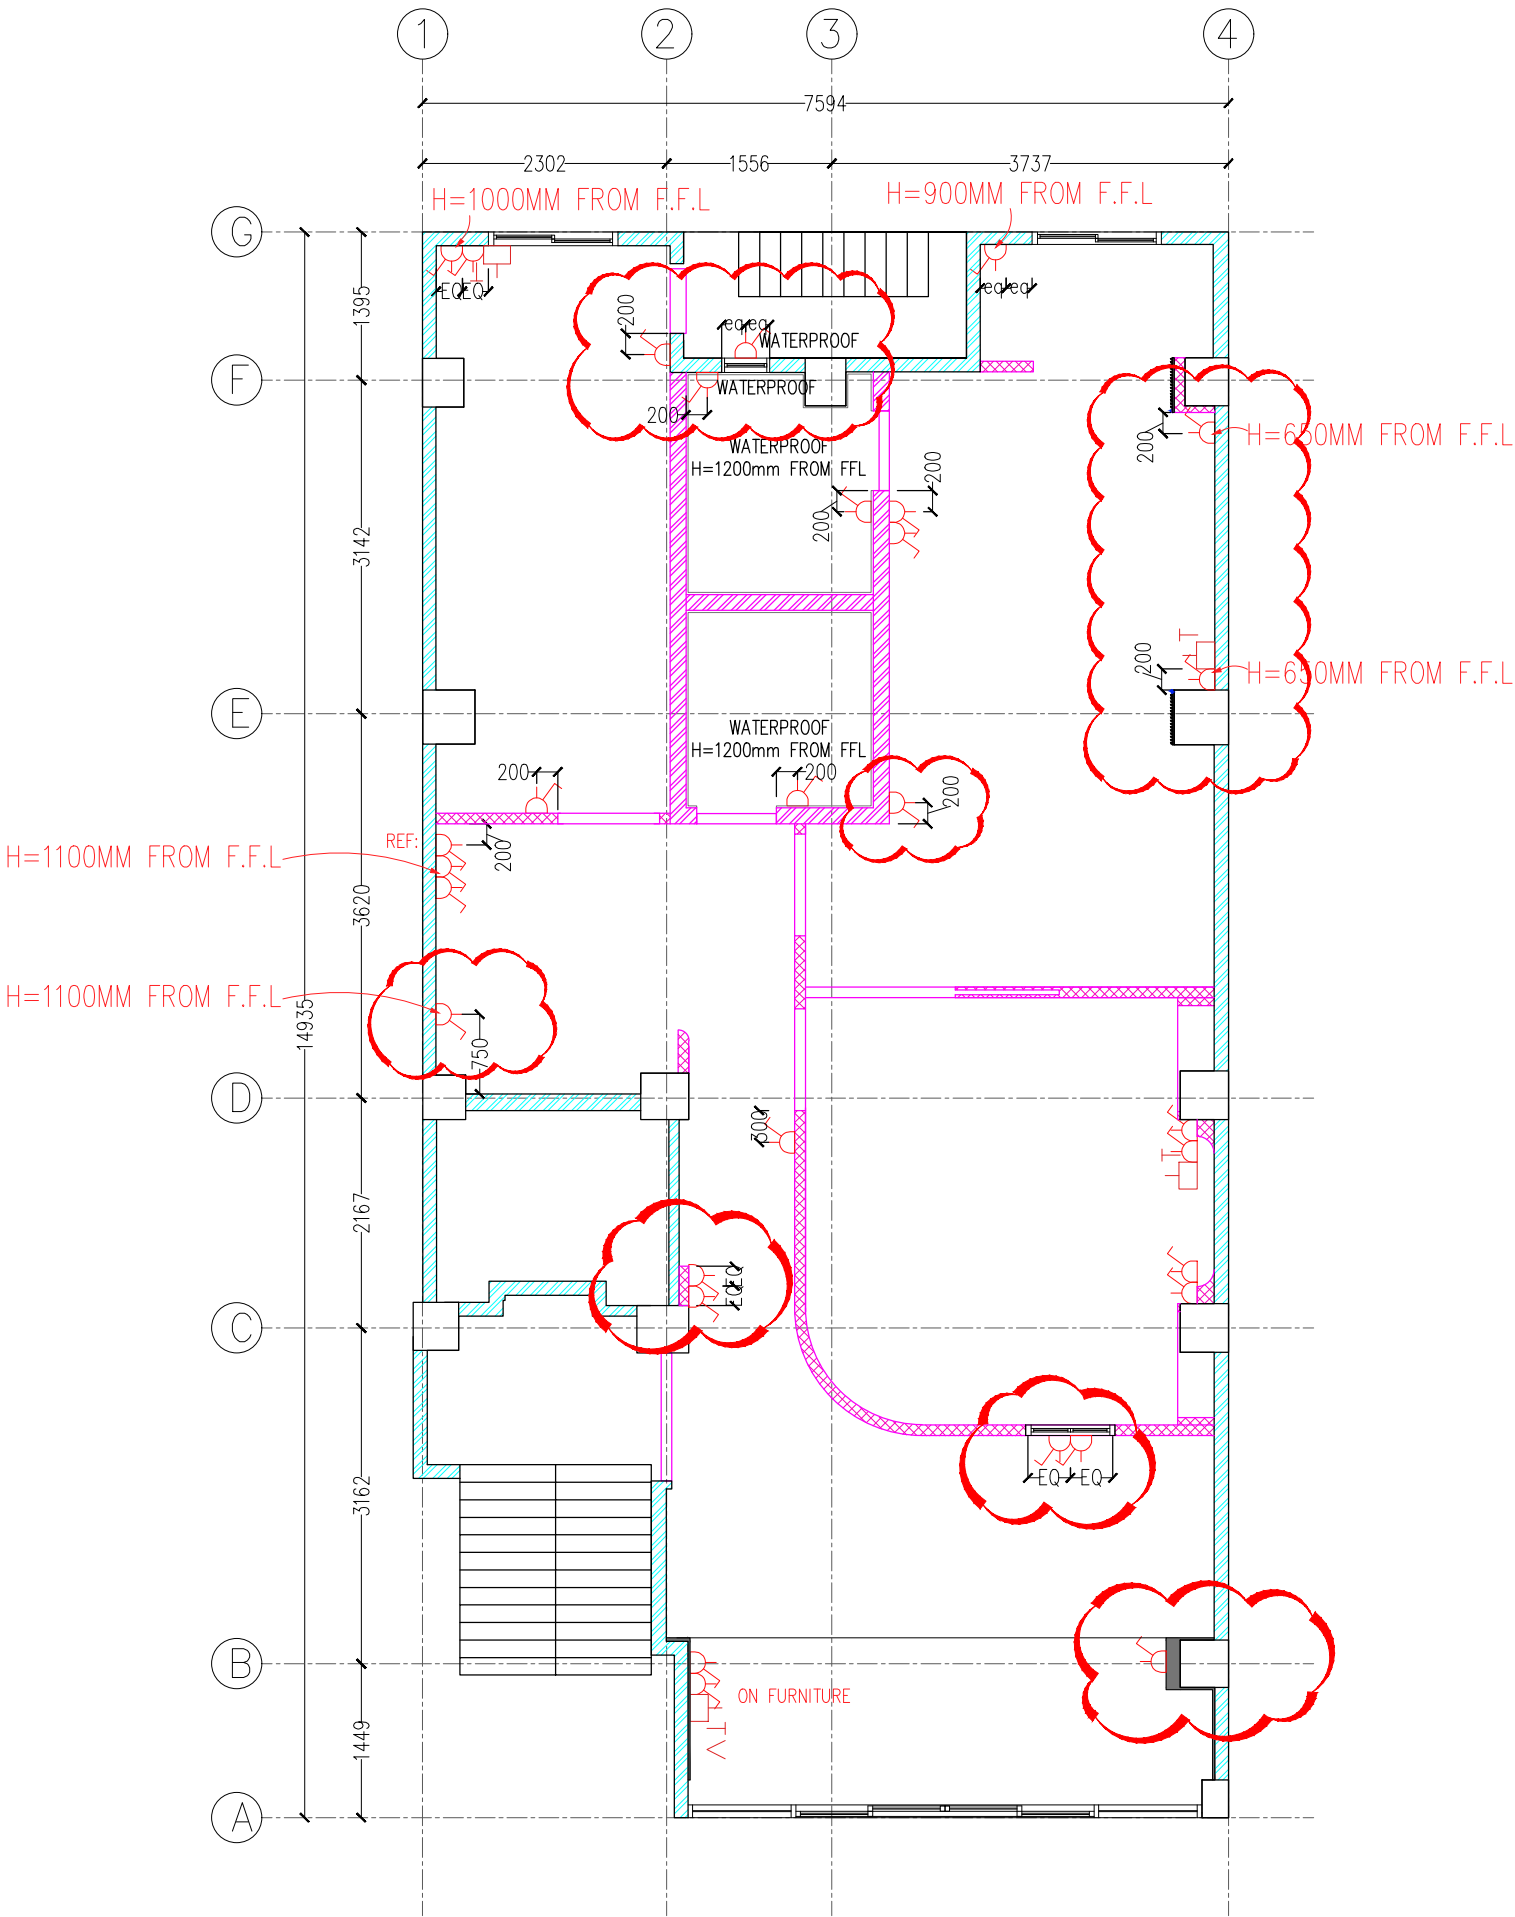

NOTE: THE GENERAL HEIGHT OF MULTI SWITCH-SOCKET OUTLET CENTER = 450MM FROM FLOOR FINISHED LEVEL(EXCEPT THOSE WITH HEIGHT MENTIONED)
THIS DRAWING IS NOT A M&E DRAWING. CHECKING AND NEGOTIATION WILL BE DONE BY M&E CONSULTANT.

TV SOCKET
MULTI SWITCH SOCKET



REVISION

PROJECT

INTERIOR DESIGN FOR
13TH STREET APARTMENT
(FOURTH FLOOR)

OWNER / APPLICANT

SUBJECT

POWER LAYOUT PLAN

SCALE

1:100


DATE

L.S

SHEET NO.

4F-I-1.08

(FOURTH FLOOR)

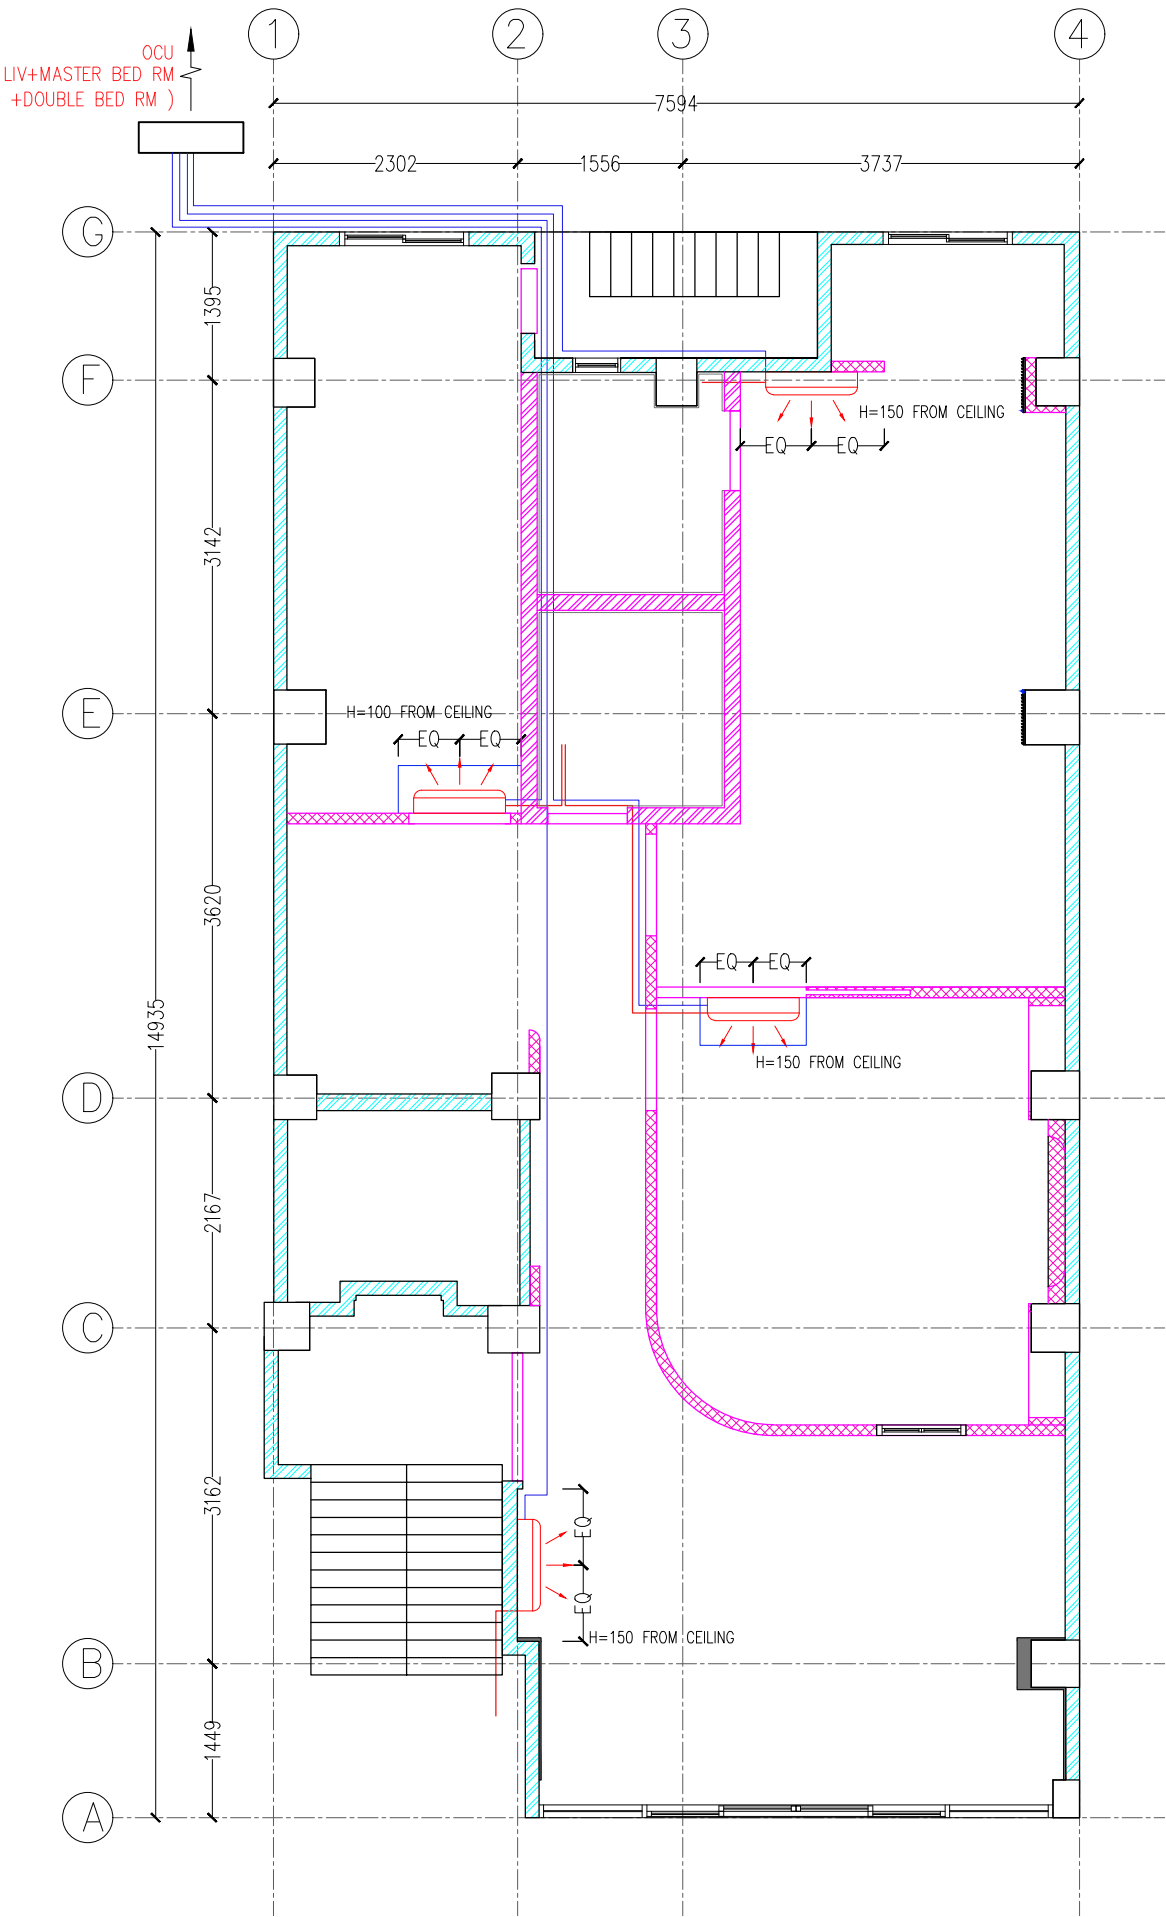

- EXISTING BRICK WALL
- NEW BRICK WALL
- NEW DRY WALL
(8MM TK CEMENT BOARD)

NOTE: THIS DRAWING IS NOT A M&E DRAWING. CHECKING AND NEGOTIATION WILL BE DONE BY M&E CONSULTANT.



REVISION

PROJECT

INTERIOR DESIGN FOR
13TH STREET APARTMENT
(FOURTH FLOOR)

OWNER / APPLICANT

SUBJECT

AIR-CON PLAN

SCALE

1:100

DATE

L.S


SHEET NO.

4F-I-1.09

AIRCON DRAIN PIPE
GAS PIPE

INTERIOR DESIGN FOR
13TH STREET APARTMENT

(FOURTH FLOOR)

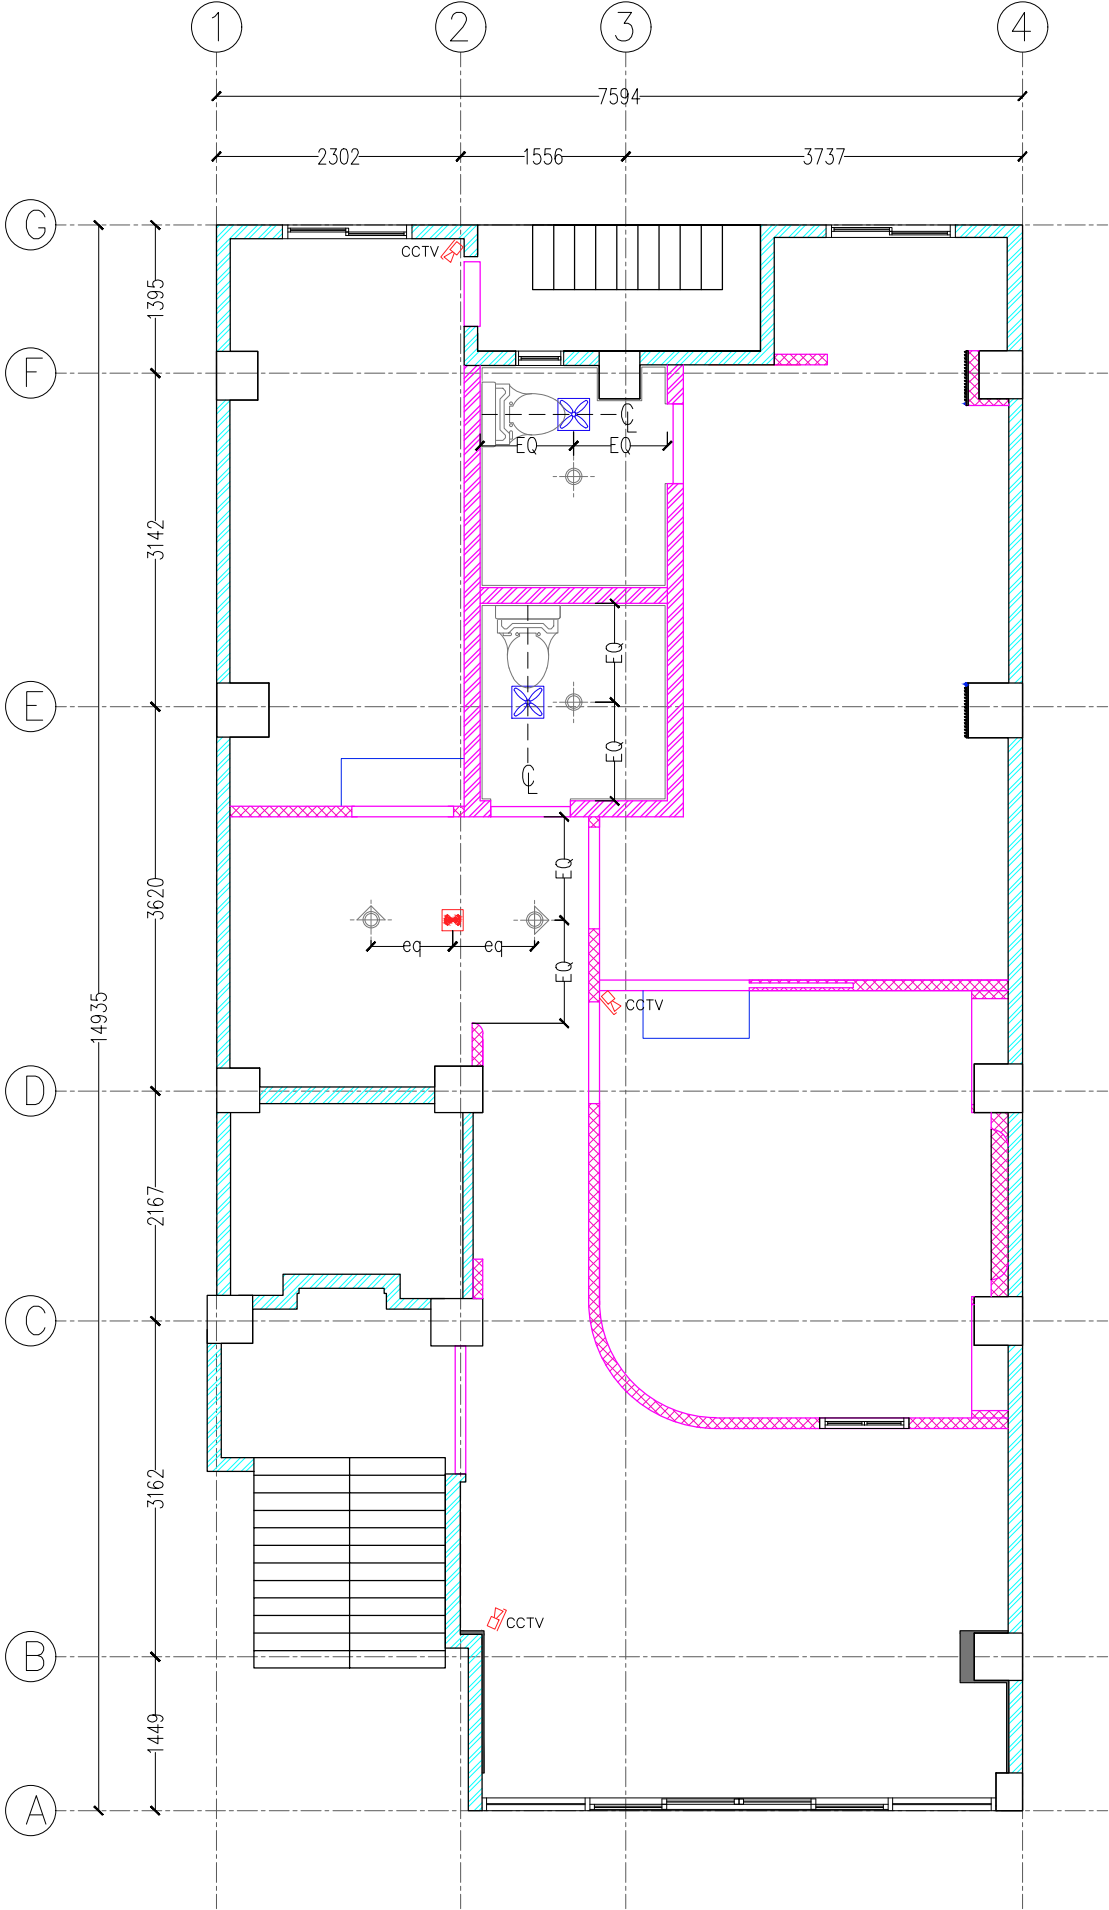

- EXISTING BRICK WALL
- NEW BRICK WALL
- NEW DRY WALL
(8MM TK CEMENT BOARD)

- EXHAUST FAN
- CCTV
- ROUTER



REVISION

PROJECT

INTERIOR DESIGN FOR
13TH STREET APARTMENT

(FOURTH FLOOR)

OWNER / APPLICANT

SUBJECT

CCTV, ROUTER &
EXHAUST FAN PLAN

SCALE

1:100

DATE

L.S

SHEET NO.

4F-I-1.10

NOTE: THIS DRAWING IS NOT A M&E DRAWING. CHECKING AND NEGOTIATION WILL BE DONE BY M&E CONSULTANT.